


UPPER FLOOR

LEGEND	
	FLUID SUPPLY LINE, TYPE 'L' HARD COPPER, INSULATED
	FLUID RETURN LINE, TYPE 'L' HARD COPPER, INSULATED
	CONDENSATE DRAIN LINE, TYPE 'L' HARD COPPER
	COMPRESSED AIR LINE, TYPE 'L' HARD COPPER

PLUMBING EQUIPMENT SCHEDULE	
Ⓜ	IN-LINE PUMP: FOR GROUND SOURCE WATER, 5 GPM @ 9 FT. W.C., IN-LINE, 120 VOLT 1 PH. 60 HZ, BELL & GOSSETT SERIES 60, TACO, OAE

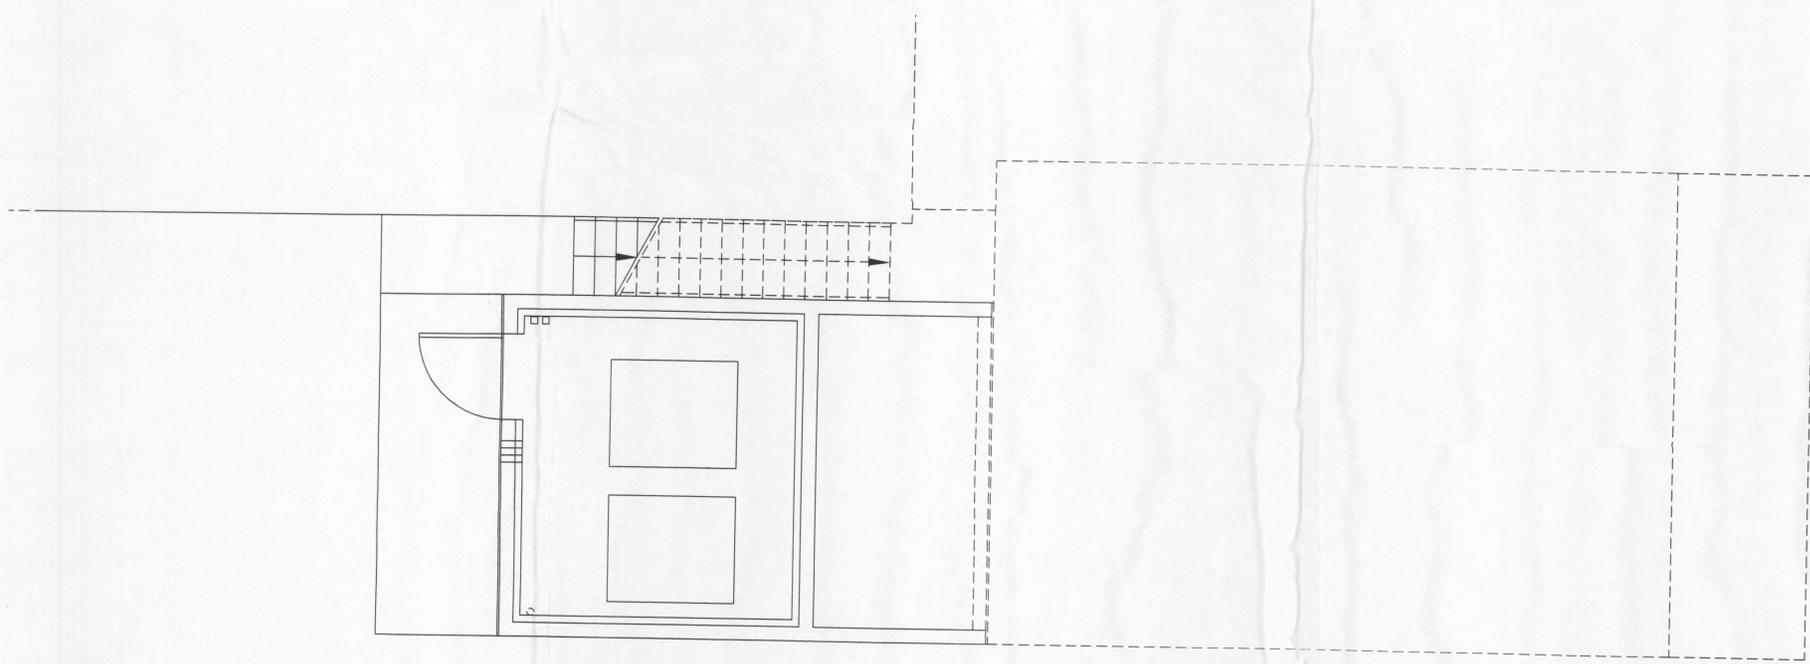

LOWER FLOOR

APACHE POINT  
OBSERVATORY  
SDSS BLDG EXPANSION

PREPARED FOR  
ASTROPHYSICAL  
RESEARCH CONSORTIUM  
SUNSPOT  
NEW MEXICO

DATE	PHASE
4/26/07	PRELIMINARY
7/13/07	PERMIT

**denton ventures, inc.**  
architecture • engineering • planning  
2480 roadrunner parkway  
las cruces, nm 88011  
office 505.525.0241  
fax 505.525.9405  
email dv@zianet.com



PLUMBING PLAN  
SCALE: 1/4" = 1'-0"

SHEET  
**P1**  
D96PLUM